

LUMINAIRE SCHEDULE

CALLOUT	SYMBOL	DESCRIPTION	LAMP	BALLAST	MOUNTING	MODEL	INPUT WATTS	VOLTS	NOTES
Z2		EXTERIOR WEDGE LIGHT, 11.5"W X 9"H X 7"D, FULL CUTOFF, FORWARD THROW	(1) 15W LED 4000K	ELECTRONIC	WALL	LITHONIA WEDGE2 LED P2 40K 90 CRI VF MVOLT DDBXD	15	MULTIPLE	EXTERIOR
Z7-WA		16' POLE LIGHT, FULL CUTOFF, TYPE IV, BRONZE, HOUSE SIDE SHIELD	(1) 52W LED 4000K	0-10V DIM	16' SQUARE STEEL POLE, 4" SQUARE, WITH CONCRETE BASE	EATON - STREETWORKS (FORMER COOPER LIGHTING), USSL-C01-D-U-T4-SA-BZ-HSS WITH 16" STEEL POLE AVAILABLE ACCESSORIES: VGS-B: BACK SHIELD, VGS-F: FRONT SHIELD, VGS-SIDE: SIDE SHIELDS	52	208V 2P 2W	SITE LIGHTING PARKING LOT. B2-U0-G2. PROVIDE WITH TUNING DIMMERS
Z7-WA3		16' POLE LIGHT, FULL CUTOFF, TYPE III, BRONZE, HOUSE SIDE SHIELD	(1) 52W LED 4000K	0-10V DIM	POLE	EATON - STREETWORKS (FORMER COOPER LIGHTING), USSL-C01-D-U-T3-SA-BZ-HSS WITH 16" STEEL POLE AVAILABLE ACCESSORIES: VGS-B: BACK SHIELD, VGS-F: FRONT SHIELD, VGS-SIDE: SIDE SHIELDS	52	120V 1P 2W	SITE LIGHTING PARKING LOT. B2-U0-G2. PROVIDE WITH TUNING DIMMERS
Z8		PEDESTRIAN SCALE POLE LIGHT, FROSTED LENS, TYPE III DISTRIBUTION, FULL CUTOFF, 10' STEEL POLE	(1) 48W LED 4000K	0-10V DIM	10' STEEL POLE WITH CONCRETE BASE	COOPER MESA MSA E02 LED E1 T3 DIM	48	120V 1P 2W	SITE LIGHTING, PROVIDE WITH TUNING DIMMERS



WEIR|ANDREWSON ASSOCIATES, INC ARCHITECTS & ENGINEERS
1430 4th Street
San Rafael, CA 94901
T: 415.485.9797
www.waassoc.com



ARLINGTON
6804 204TH, ST,
ARLINGTON, WA

APN:
052-19-106

MARK	DATE	DESCRIPTION
	2/22/24	UPDATE SITE

SCALE: AS INDICATED
DRAWN BY: MG
CHECKED BY: AF
JOB NUMBER: 22019

SHEET TITLE

LUM SCHEDULE

DRAWING
E-001

COPYRIGHTS 2023
WIA ASSOCIATES, INC
ALL DESIGN ARRANGEMENTS AND PLANS INDICATED OR REPRODUCED BY THIS DRAWING ARE OWNED BY WIA ASSOCIATES, INC. NO REUSE OR REPRODUCTION OF THIS DRAWING OR ANY PART THEREOF IS PERMITTED WITHOUT THE WRITTEN PERMISSION OF WIA ASSOCIATES, INC.

Z2 FIXTURE

WEDGE2 LED
Architectural Wall Sconce
Precision Refractive Optic

Specifications
Depth (D1): 7"
Depth (D2): 1.5"
Height: 11.5"
Weight (without options): 13.5 lbs

Introduction
The WEDGE2 LED family is designed to meet specific needs in a widely accepted shape that blends with any architecture. The clean rectangular design comes in four sizes with lumens packages ranging from 1,200 to 23,000 lumens, providing a true site-wide solution. Embedded with nightfall wireless controls, the WEDGE2 family provides additional energy savings and code compliance. WEDGE2 with industry leading precision refractive optics provides great uniform distribution and optical control. When combined with multiple integrated emergency battery backup options, including an 18W cold temperature option, the WEDGE2 becomes the ideal wall-mounted lighting solution for pedestrian scale applications in any environment.

Luminaire	Optics	Standard Effic, ft/c	Color Temp, °K	Beam	PL	P2	P3	P4	Approximate Lumens (4000K, 80CRI)
WEDGE2 LED	Visual Comfort	90	3000	Standard	700	1,200	2,000	—	—
WEDGE2 LED	Visual Comfort	90	3000	Standard	700	1,200	2,000	3,000	4,500
WEDGE2 LED	Precision Refractive	90	3000	Standard	700	1,200	2,000	3,000	4,500
WEDGE2 LED	Precision Refractive	90	3000	Standard	700	1,200	2,000	3,000	4,500
WEDGE2 LED	Precision Refractive	90	3000	Standard	700	1,200	2,000	3,000	4,500

Z7 FIXTURE

Project	Catalog #	Type
Prepared by	Notes	Date

Streetworks
USSL LED
Area / Site Luminaire

Product Certifications
UL, ENEC, BAA, IP66, 5 YEAR, FC

Interactive Menu

- Order Information page 2
- Mounting Details page 3, 4
- Optical Configurations page 5
- Product Specifications page 5
- Energy and Performance Data page 6, 7
- Control Options page 8

Quick Facts

- Lumen packages range from 4,800 - 84,000 lumens (35W - 588W)
- Replaces 70W up to 1,000W HID equivalents
- Efficacies up to 160 lumens per watt
- Energy and maintenance savings up to 85% versus HID solutions
- Standard universal quick mount arm with universal drill pattern

Dimensional Details

Z8 FIXTURE

Project	Catalog #	Type
Prepared by	Notes	Date

Invue
MSA MESA
Decorative Area Luminaire

Product Certifications
UL, ENEC, BAA, IP66, 5 YEAR, FC



Interactive Menu

- Order Information page 2
- Optical Distributions page 3
- Product Specifications page 4
- Energy & Performance data page 5
- Control Options page 8

Quick Facts

- Die-cast aluminum housing and door
- Lumens packages ranging from 3,000 - 29,000 lumens
- Choice of 13 high-efficiency, patented AccuLED Optics™
- Base casting slip fits over a standard 3" O.D. tenon
- Wall, single and dual mount configurations available
- 10kV/10kVA surge protection standard
- LED fixture features a five-year warranty

Dimensional and Mounting Details

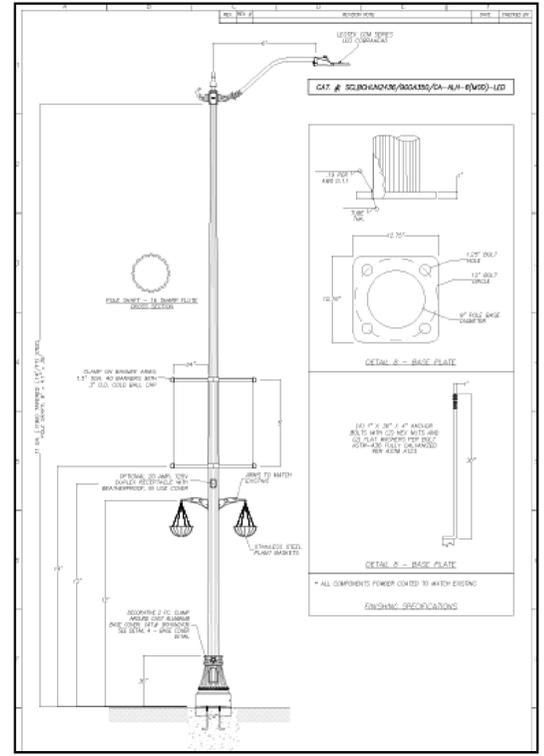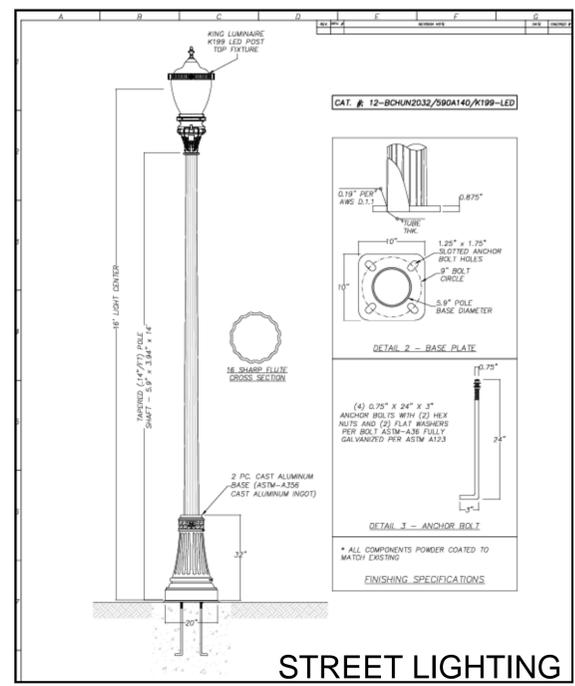

ARLINGTON

6804 204TH, ST,
ARLINGTON, WA

APN:
052-19-106

MARK	DATE	DESCRIPTION
	2/22/24	UPDATE SITE


SCALE:	AS INDICATED
DRAWN BY:	MG
CHECKED BY:	AF
JOB NUMBER:	22019

SHEET TITLE
LIGHTING SITE PLAN

DRAWING

E-100

COPYRIGHTS 2023
WA ASSOCIATES, INC.
ALL DESIGN ARRANGEMENTS AND PLANS INDICATED OR REFERENCED BY THIS DRAWING ARE OWNED BY WA ASSOCIATES, INC. NO PART OF THIS DRAWING OR ANY INFORMATION HEREON MAY BE REPRODUCED OR TRANSMITTED IN ANY FORM OR BY ANY MEANS, ELECTRONIC OR MECHANICAL, INCLUDING PHOTOCOPYING, RECORDING, OR BY ANY INFORMATION STORAGE AND RETRIEVAL SYSTEM, WITHOUT THE WRITTEN PERMISSION OF WA ASSOCIATES, INC.

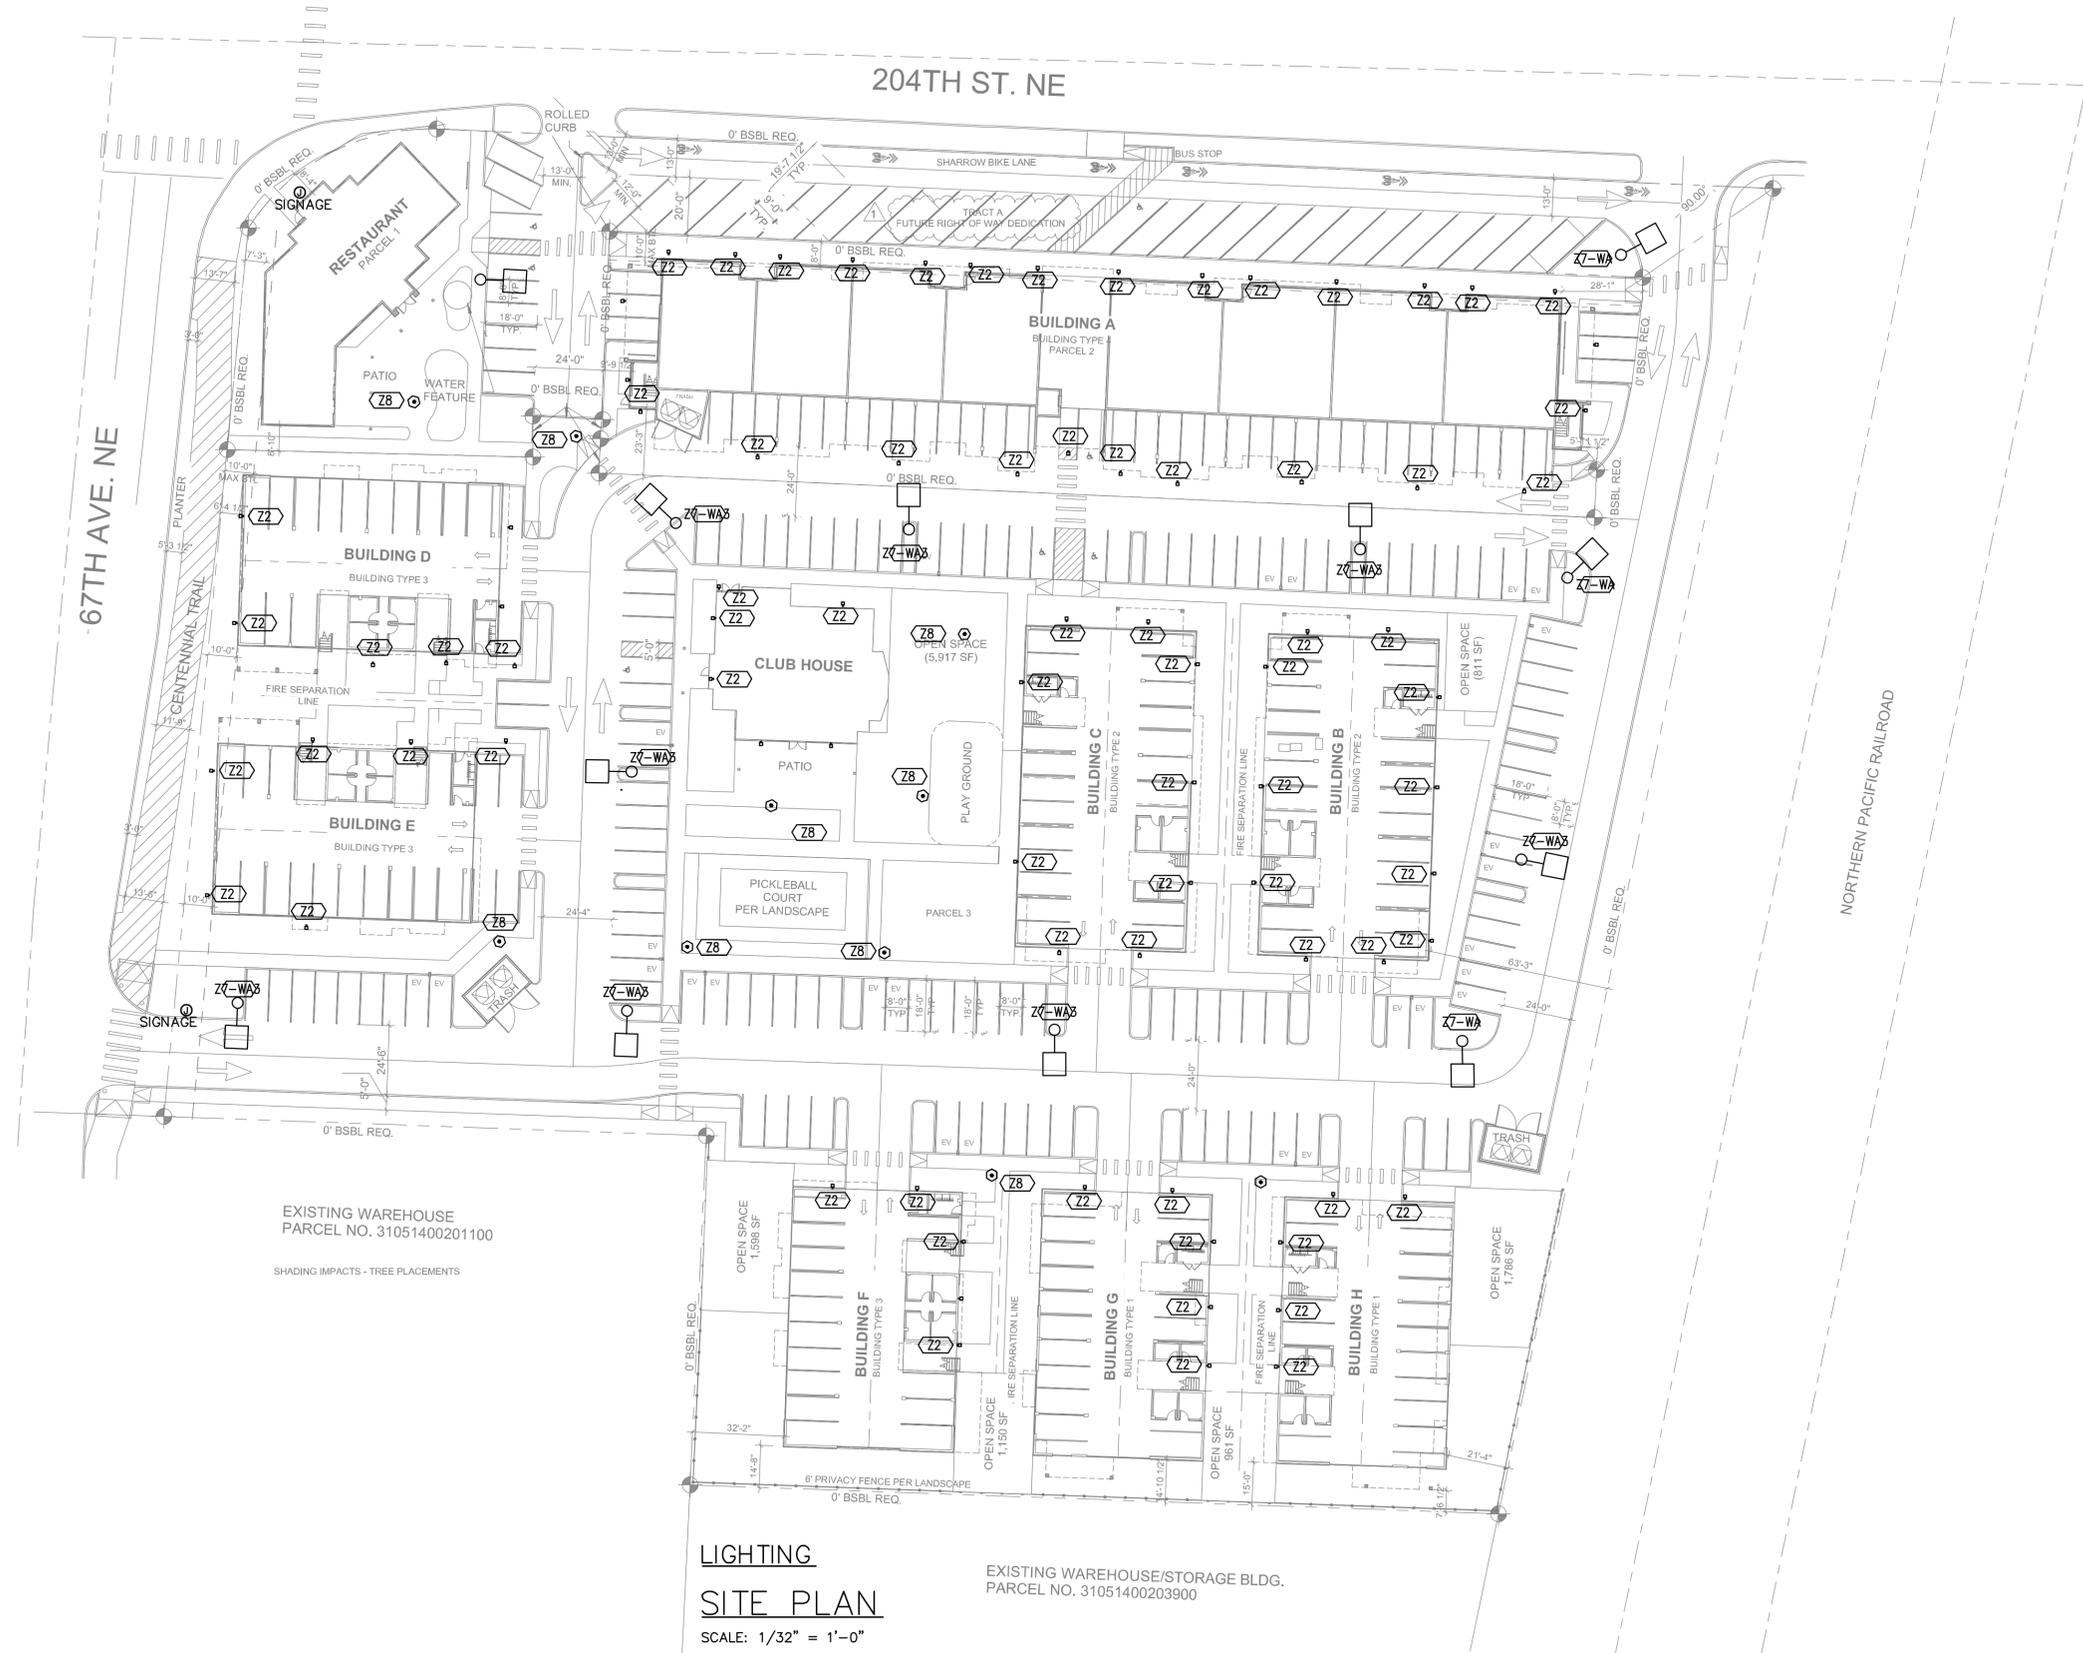

LIGHTING SITE PLAN
SCALE: 1/32" = 1'-0"

EXISTING WAREHOUSE/STORAGE BLDG.
PARCEL NO. 31051400203900

EXISTING WAREHOUSE
PARCEL NO. 31051400201100

SHADING IMPACTS - TREE PLACEMENTS



DIRECT NORTH

(1" = 60'-0" WHEN SHEET SIZE IS 11" X 17")



ARLINGTON

6804 204TH, ST,
 ARLINGTON, WA

APN:
 052-19-106

MARK	DATE	DESCRIPTION
	2/22/24	UPDATE SITE

SCALE:	AS INDICATED
DRAWN BY:	MG
CHECKED BY:	AF
JOB NUMBER:	22019

SHEET TITLE
PHOTOMETRICS

DRAWING

E-101

COPYRIGHTS 2023
 WA ASSOCIATES, INC.
ALL DESIGN, DESIGN ARRANGEMENTS, AND PLANS INDICATED OR REFERENCED BY THIS DRAWING ARE OWNED BY WA ASSOCIATES, INC. SPECIFIC PROTECTION OF THE DESIGN AND CONSTRUCTION WITH THIS SHEET SHALL BE THE RESPONSIBILITY OF THE ARCHITECT/ENGINEER WITHOUT THE WRITTEN PERMISSION OF WA ASSOCIATES, INC.



PHOTOMETRICS
SITE PLAN
 SCALE: 1/32" = 1'-0"

EXISTING WAREHOUSE/STORAGE BLDG.
 PARCEL NO. 31051400203900

EXISTING WAREHOUSE
 PARCEL NO. 31051400201100

SHADING IMPACTS - TREE PLACEMENTS



OBJECT
 NORTH

(1" = 60'-0" WHEN SHEET SIZE IS 11" X 17")