

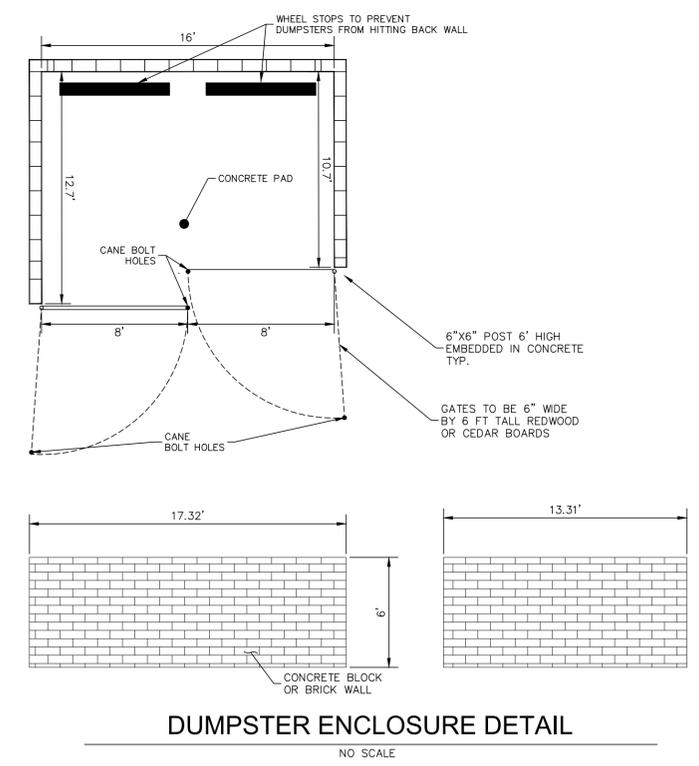
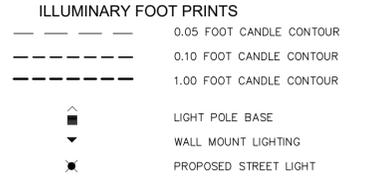


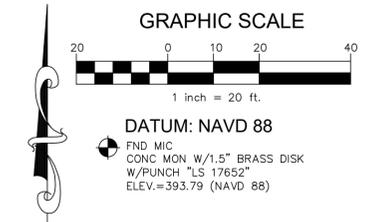

CITY OF ARLINGTON - LOT 7 AT THE DISTRICT CONDITIONAL USE - PLN #  
 PORTION SW1/4, SW1/4, SEC.24, TWP.31N, RGE.5E, W.M.

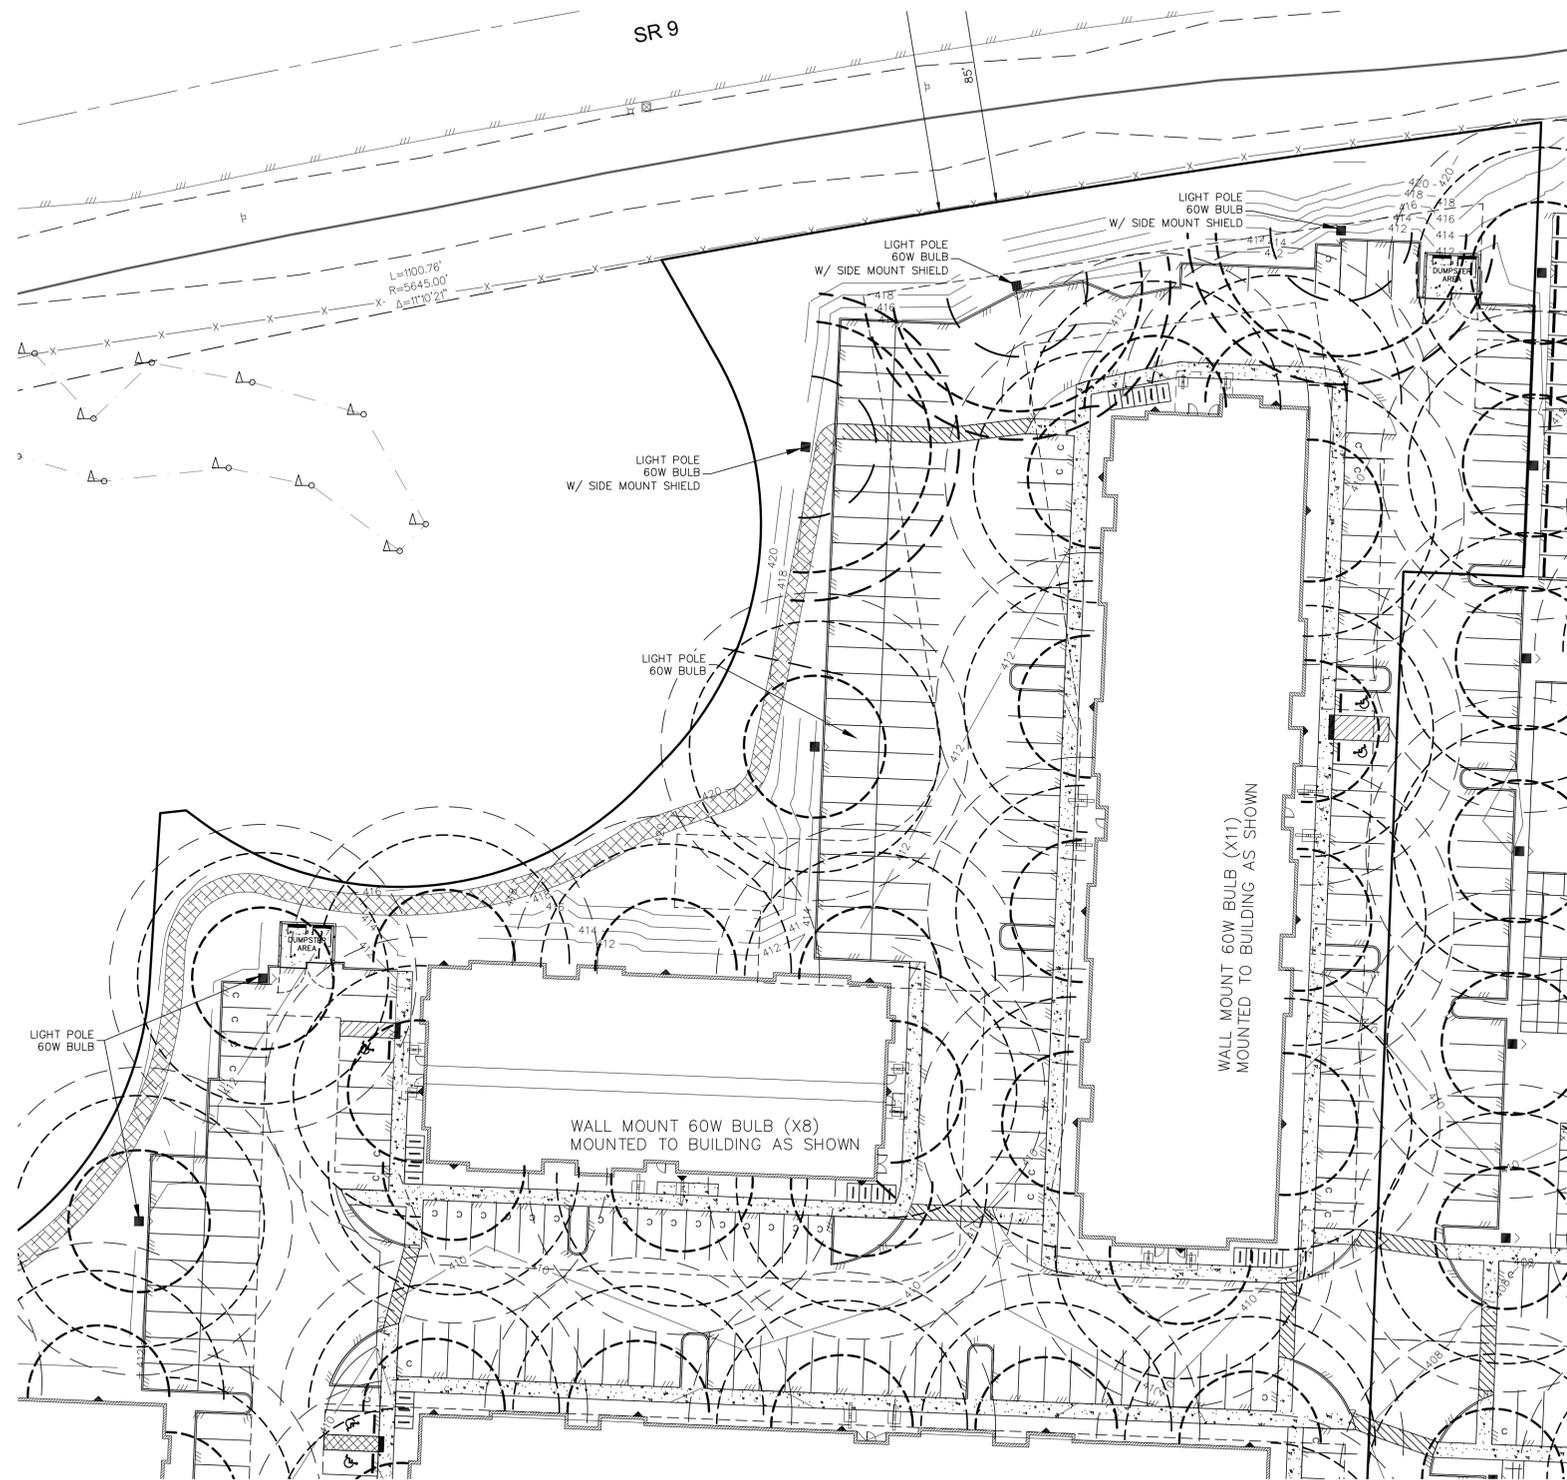

**CASCADE SURVEYING & ENGINEERING, INC.**  
 Engineers Surveyors Planners  
 P.O. BOX 326 SUUNISTON, NE223  
 WASHINGTON, WA 98148  
 WWW.CASCADESURVEYING.COM  
 (360) 635-5551

NO.	DATE	BY

DESIGNED	JH	DATE	8/23	DRAWN	JH	DATE	8/23	CHECKED		DATE		FIELD BOOK	ARL 141	REF.

**GRANDVIEW NORTH LLC**  
 LOT 7 AT THE DISTRICT  
 CONDITIONAL USE PERMIT  
 LIGHTING PLAN  
 CITY OF ARLINGTON CITY FILE NO.: PLN #